



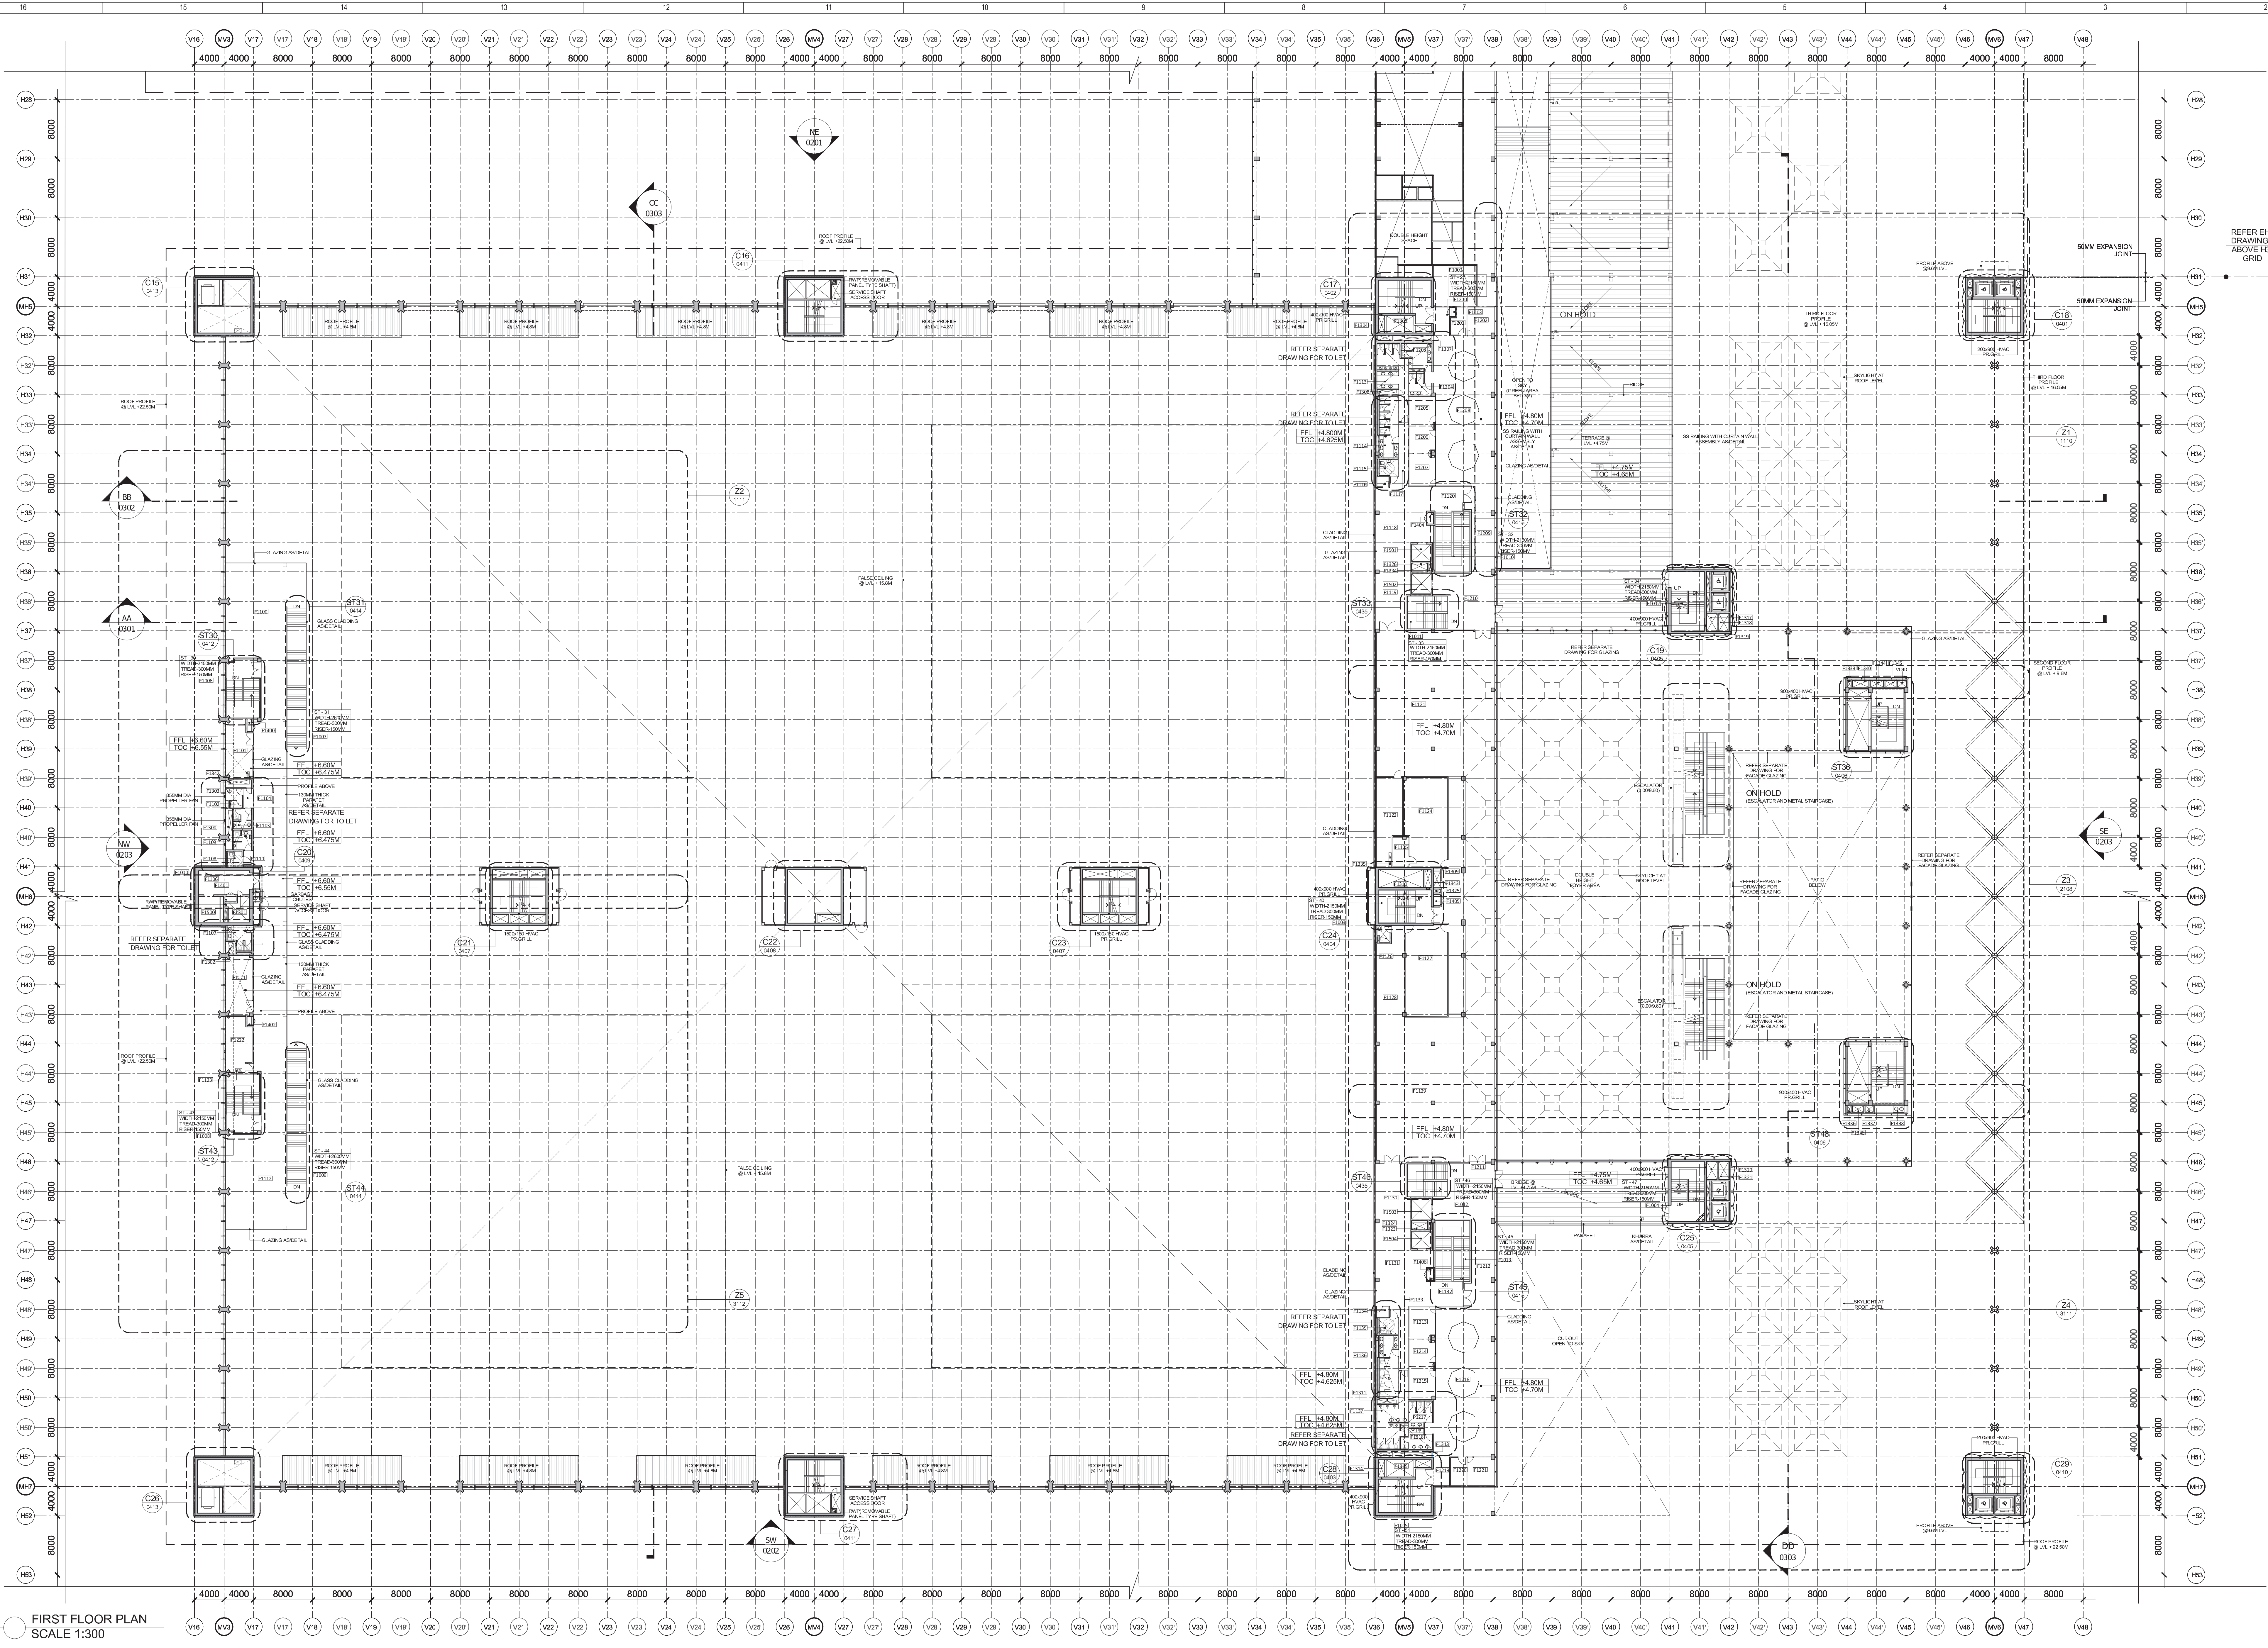

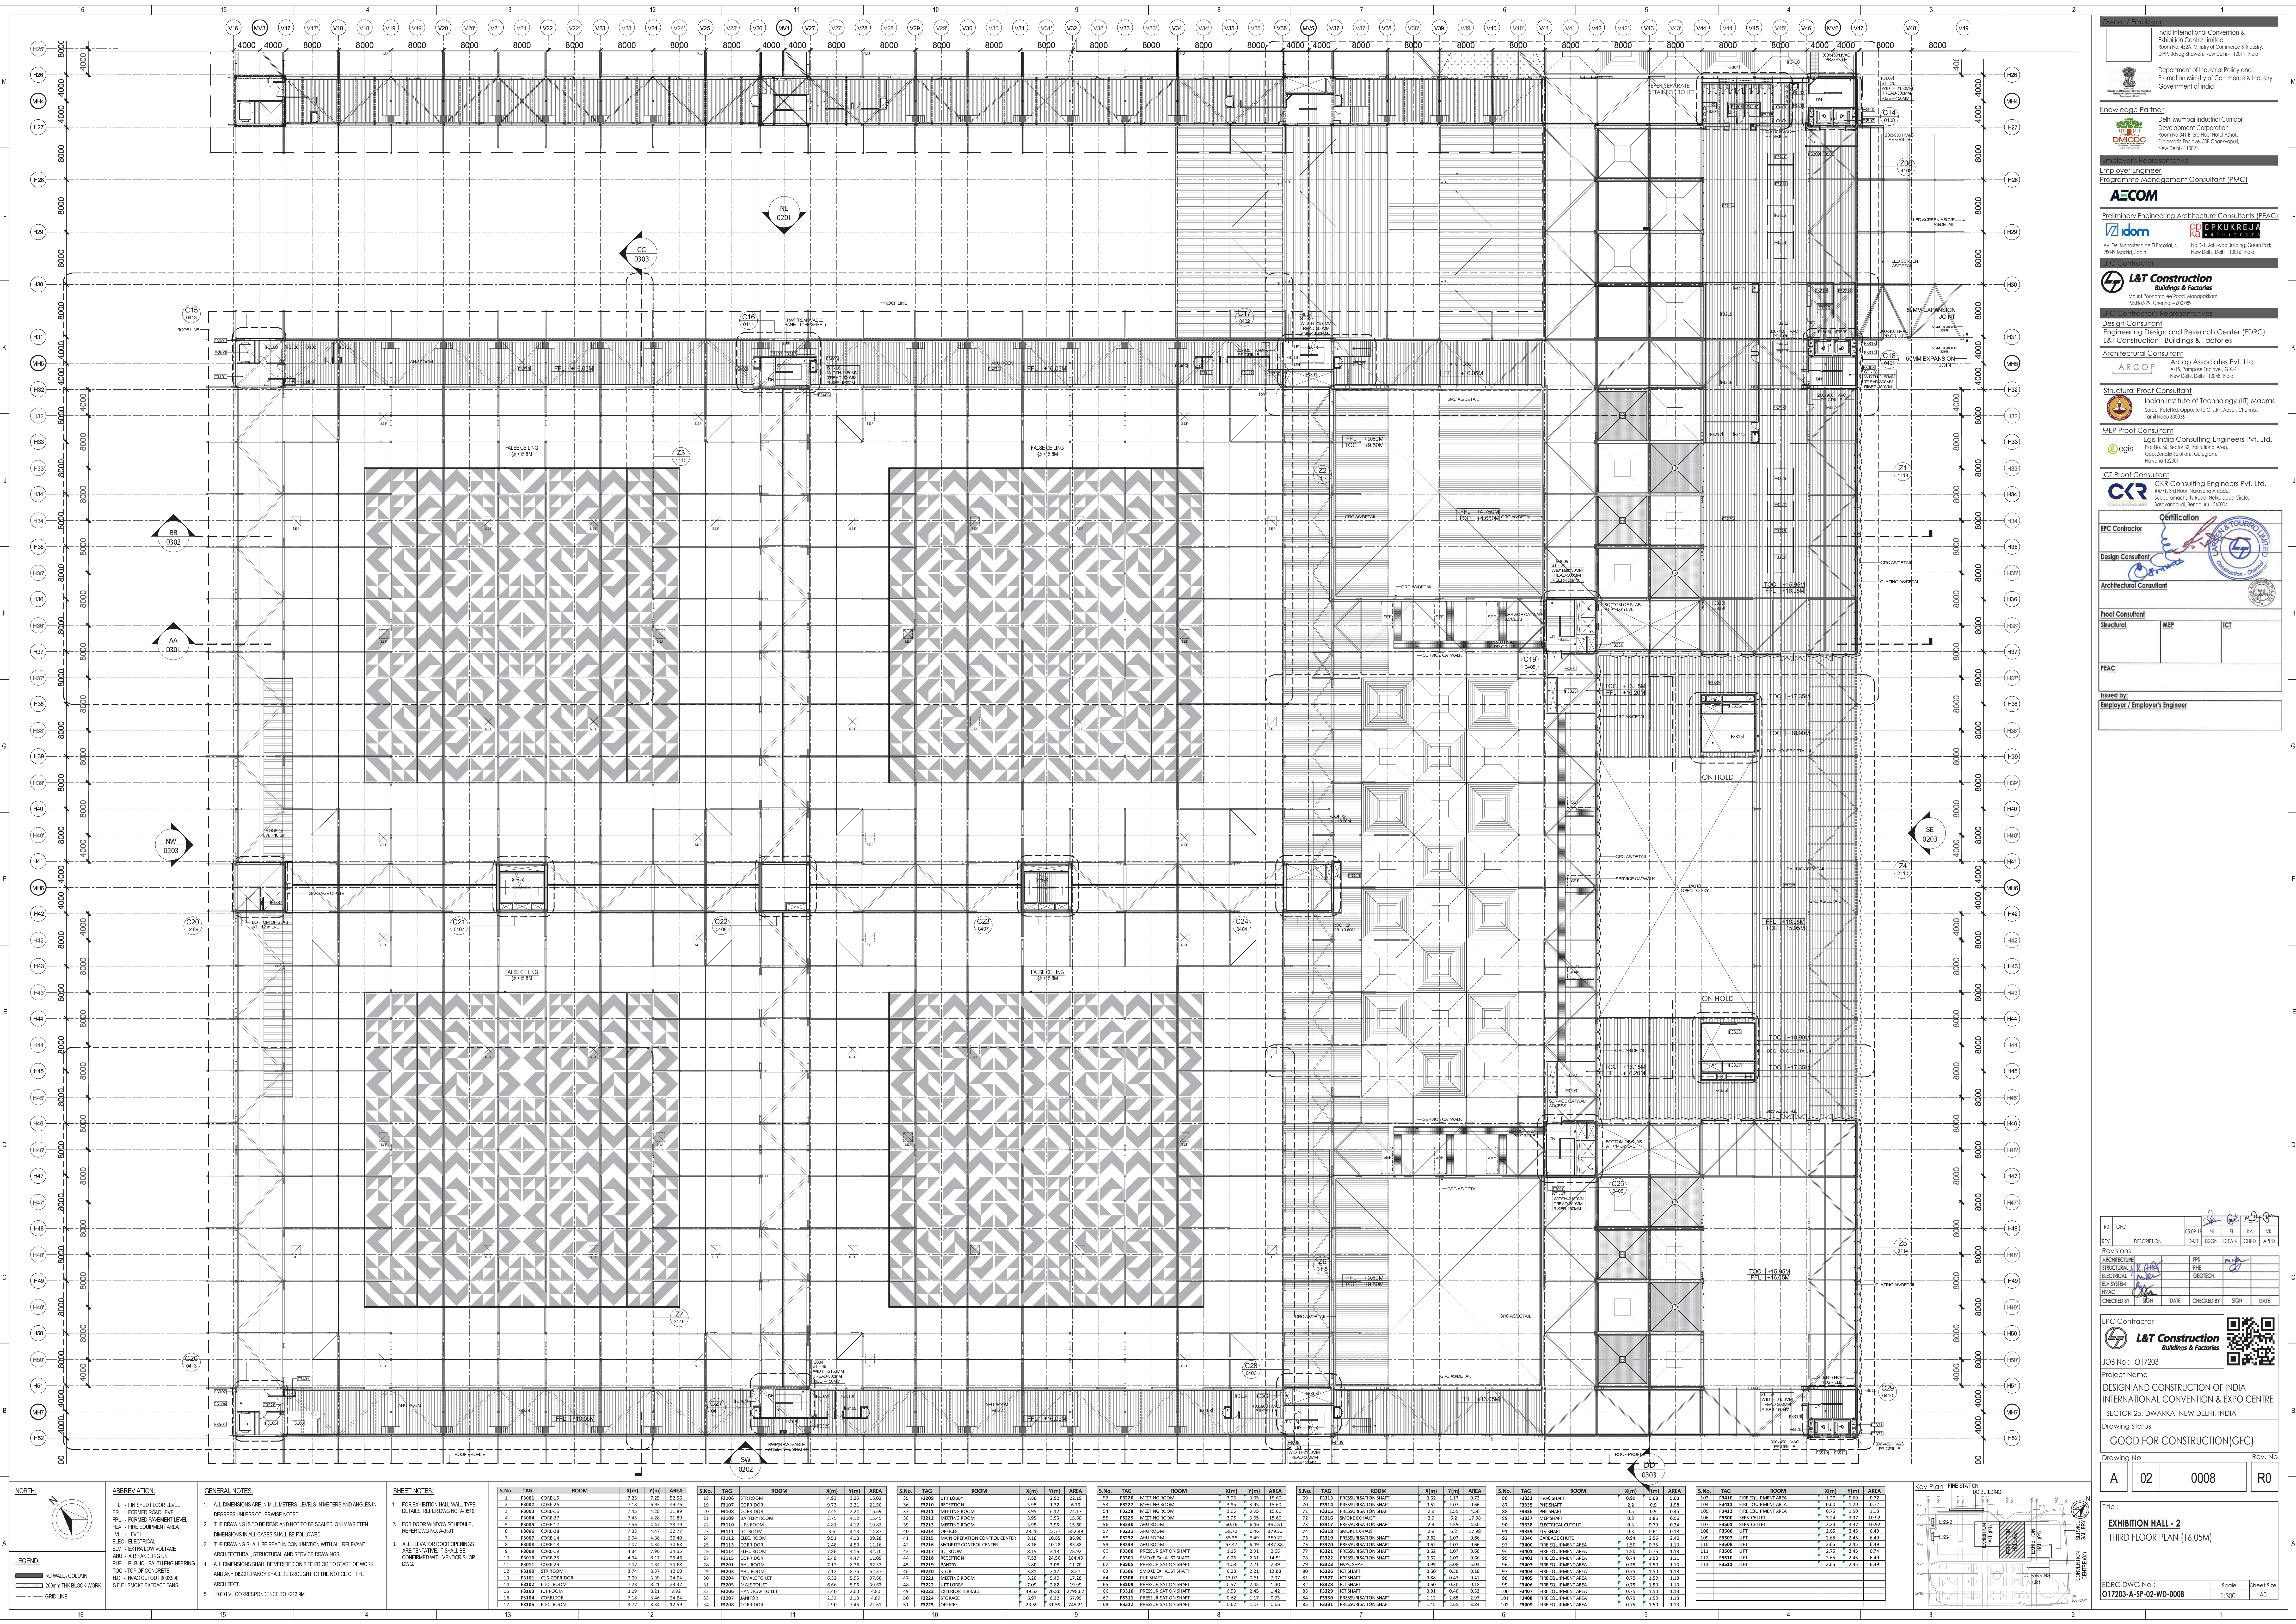

India International Convention & Exhibition Centre Limited
Room No. 404, Ministry of Commerce & Industry,
DIP, Vajra Bhawan, New Delhi - 110011, India

Department of Industrial Policy and
Promotion Ministry of Commerce & Industry
Government of India

Knowledge Partner
Delhi Mumbai Industrial Corridor
Development Corporation
Room No. 301 & 302, Ministry of Commerce & Industry,
DIP, Vajra Bhawan, New Delhi - 110011, India

Employer Engineer
Programme Management Consultant (PMC)
AECOM
Preliminary Engineering Architecture Consultants (PEAC)
idom **SPKUREJA**
Au. Del. Monopoli, de R. Eccecl. 4
2049 Model, Spain
H.O. 1, Ashwini Building, Green Park,
New Delhi - 110016, India

Design Consultant
Engineering Design and Research Center (EDRC)
L&T Construction - Buildings & Factories
ARCOP Arcop Associates Pvt. Ltd.
A-15, Parkside Enclave, C-1
New Delhi, Delhi 110016, India

Structural Proof Consultant
Indian Institute of Technology (IIT) Madras
Sanjay Prasad, Opposite to C. I. L. Ashwini, Chennai,
Tamil Nadu, 600036

MEP Proof Consultant
Egis India Consulting Engineers Pvt. Ltd.
Rajiv Mehta, Sector 32, Industrial Area,
Opp. Jindal Steels, Gurgaon,
Haryana 122001

ICT Proof Consultant
C&R Consulting Engineers Pvt. Ltd.
4/71, 3rd Floor, Naraina Arcade,
Lokesh Chandra Road, Naraina Circle,
New Delhi - 110028

EPC Contractor
Design Consultant
Architectural Consultant
Proof Consultant
Structural
MEP
ICT
PEAC
Issued by:
Employer / Employer's Engineer

REV	DESCRIPTION	DATE	DESIGN	DRAWN	CHECKED	APPROVED
1	FOR EXHIBITION HALL WALL TYPE DETAILS, REFER TO DWG NO. A/010.	25.08.16	N	B	KA	VK
2	FOR DOOR AND WINDOW SCHEDULE, REFER TO DWG NO. A/001.	25.08.16	N	B	KA	VK
3	FOR DOOR AND WINDOW SCHEDULE, REFER TO DWG NO. A/001.	25.08.16	N	B	KA	VK
4	FOR DOOR AND WINDOW SCHEDULE, REFER TO DWG NO. A/001.	25.08.16	N	B	KA	VK
5	FOR DOOR AND WINDOW SCHEDULE, REFER TO DWG NO. A/001.	25.08.16	N	B	KA	VK

ARCHITECTURE
STRUCTURAL
ELECTRICAL
MECHANICAL
HVAC
CHECKED BY
SIGN
DATE
CHECKED BY
SIGN
DATE

EPC Contractor
L&T Construction
Buildings & Factories
JOB No: 017203
Project Name
DESIGN AND CONSTRUCTION OF INDIA
INTERNATIONAL CONVENTION & EXPO CENTRE
SECTOR 25, DWARKA, NEW DELHI, INDIA
Drawing Status
GOOD FOR CONSTRUCTION (GFC)
Drawing No
A 02 0008 R0
Title:
EXHIBITION HALL - 2
THIRD FLOOR PLAN (16.05M)
EDRC DWG No: 017203-A-SF-02-WD-0008
Scale: 1:300
Sheet Size: A0